


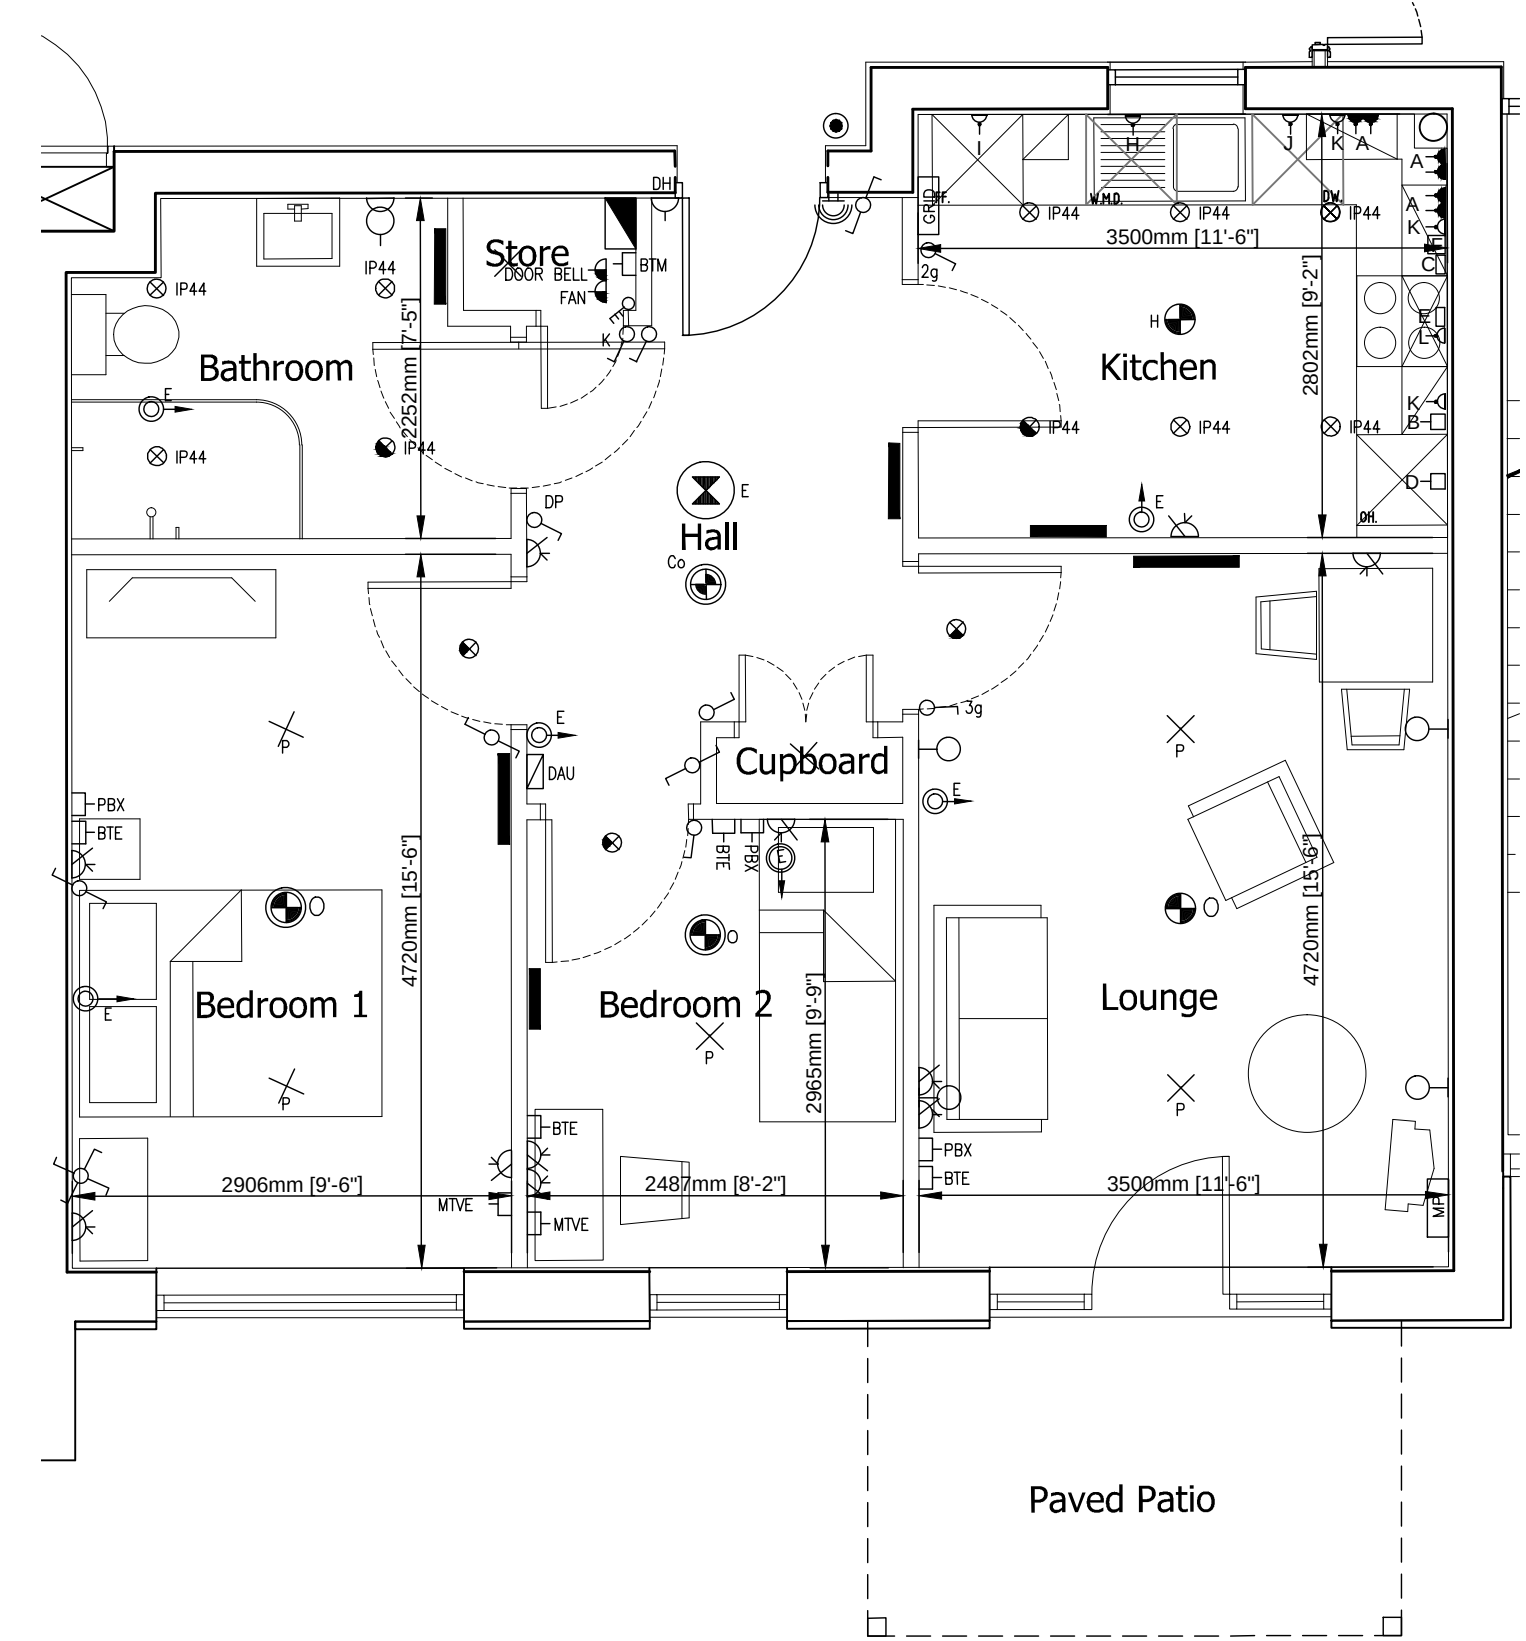

LEGEND

- 

1 WAY LIGHT SWITCH (DP=DOUBLE POLE)

2 WAY LIGHT SWITCH (WIDE ROCKER TYPE)

FAN ISOLATING SWITCH

EMERGENCY LIGHTING KEY SWITCH

INTERMEDIATE SWITCH

TELEPHONE OUTLET

BT MASTER TELEPHONE OUTLET

BT EXTENSION TELEPHONE OUTLET WIRED TO BT MASTER OUTLET.

MATV SYSTEM - MASTER

MATV - TV OUTLET EXTENSION

SATV SYSTEM - MASTER

HEAT DETECTOR

OPTICAL SMOKE DETECTOR

OPTICAL SMOKE DETECTOR (SOUNDER BASE)

CARBON MONOXIDE DETECTOR (SOUNDER BASE)

EMERGENCY PULL CORD

UNDER CUPBOARD LIGHT

DOOR BELL SOUNDER

DOOR BELL PUSH

EXTRACTOR FAN

ENERGY SAVING CEILING MOUNTED LIGHT

CEILING ROSE WITH LOW ENERGY LIGHT

CIRCULAR LIGHT

LED NON MAINTAINED EMERGENCY LIGHT. FIRE RATED AND WITH INSULATION SUPPORT BOX ON TOP FLOOR APARTMENTS.
- 

WALL LIGHT AS FRANKLITE WB243EL/8SS

TWIN SWITCHED SOCKET (NEON INDICATOR)

SWITCHED SOCKET (NEON INDICATOR)

FIRE DOOR CLOSER CONNECTION POINT (these are wired from external fire alarm system)

TV MASTER UNIT

DISPERSED ALARM UNIT WITH PULL CORD

SHAVER POINT

CONSUMER UNIT (low level) - 1200mm

RADIATOR

3 GANG GRID SWITCH c/w FOLLOWING SWITCHES
 - WASHING MACHINE/DRYER
 - FRIDGE FREEZER
 - DISHWASHER

NOTE: ENHANCED FLATS HAVE A 4 GANG SWITCH WHICH INCLUDES A SWITCH FOR THE COOKER HOOD

SWITCHED FCU

ENERGY SAVING 18W TC-TEL LAMP, HF, RECESSED DOWNLIGHTER WITH WHITE BEZEL IP44, CLEAR GLASS ATTACHMENT, 125 # MM MAX, COMPLETE. FIRE RATED LUMINAIRES SHALL BE FITTED THROUGH FIRE RATED CEILINGS, AS AURORA LPF650+LPF683. ALL TOP FLOOR APARTMENT RECESSED LUMINAIRES SHALL BE ENCLOSED WITHIN AN INSULATION SUPPORT BOX TO ENSURE FREE AIR SURROUNDS THE LUMINAIRE.

W DENOTES FROSTED GLASS ATTACHMENT

ENERGY SAVING 18W TC-TEL LAMP, HF, RECESSED DOWNLIGHTER WITH WHITE BEZEL IP44, CLEAR GLASS ATTACHMENT, 125 # MM MAX, COMPLETE. WITH INVERTER AND 3 HOUR EMERGENCY BATTERY PACK. FIRE RATED LUMINAIRES SHALL BE FITTED THROUGH FIRE RATED CEILINGS, AS AURORA LPF650+LPF683. ALL TOP FLOOR APARTMENT RECESSED LUMINAIRES SHALL BE ENCLOSED WITHIN AN INSULATION SUPPORT BOX TO ENSURE FREE AIR SURROUNDS THE LUMINAIRE.

MEDIA PLATE CONTAINING FOLLOWING:
 - 3-TWIN 13A SOCKETS
 - 1-BT OUTLET
 - 1-PBX OUTLET AND ALL OUTLETS TO RECEIVE DTV, FM, DAB, SKY+, FREESAT & SKY RETURN


* WHERE BTE AND PBX OUTLETS ARE INSTALLED TOGETHER, THEY SHALL BE MOUNTED AS A TWIN OUTLET PLATE FIXED ONTO A SINGLE SOCKET BOX.

Position for Integrated Fridge/Freezer.

Position for Integrated Oven Housing

Position for Integrated Washing Machine/Dryer

Position for future Dishwasher

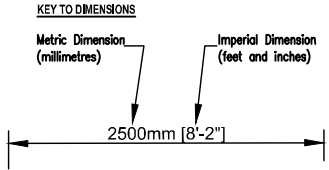

Copyright of this drawing is vested in the Architect and it must not be copied or reproduced without consent. Every effort has been made to ensure these details are correct but this does not constitute a legal document. DO NOT SCALE OFF THIS DRAWING IF IN DOUBT ASK

THE INFORMATION IN THIS LEAFLET DOES NOT IN ANY WAY FORM PART OF A CONTRACT OR WARRANTY

THE PARTICULARS ARE SENT OUT AS A GENERAL OUTLINE FOR GUIDANCE ONLY.

KITCHEN KEY	
A	TWIN 13AMP SSO
B	OVEN SWITCH
C	HOB SWITCH
D	OVEN UNSWITCHED SINGLE SOCKET
E	HOB OUTLET
F	FAN BOOST SWITCH
H	13AMP SOCKET FOR WASHER/DRYER
I	13AMP SOCKET FOR FRIDGE/FREEZER
J	13AMP SOCKET FOR FUTURE DISHWASHER
GRID	3/4 GANG GRID SWITCH CONTROLLING ITEMS H, I, J, L
K	ARCHITRAVE BOX/BLANK PLATE FOR UIC LIGHTING
L	SINGLE 13AMP SOCKET FOR COOKER HOOD

Scale. 1:50 @ A3 Date. July 2012 Drawn. nls

Client. The ExtraCare Charitable Trust

Marketing Drawings

Job title. Hagley Road, ExtraCare Retirement Village
Birmingham.

Drawing No. B5589 - Hagley Road - Apartment... 064

Lower Ground Floor -2 Block A

Apartment Type C (Enhanced)

Unit 064 Area = 65.96m²

Apartment 064 Type C (Ground Level)

