
 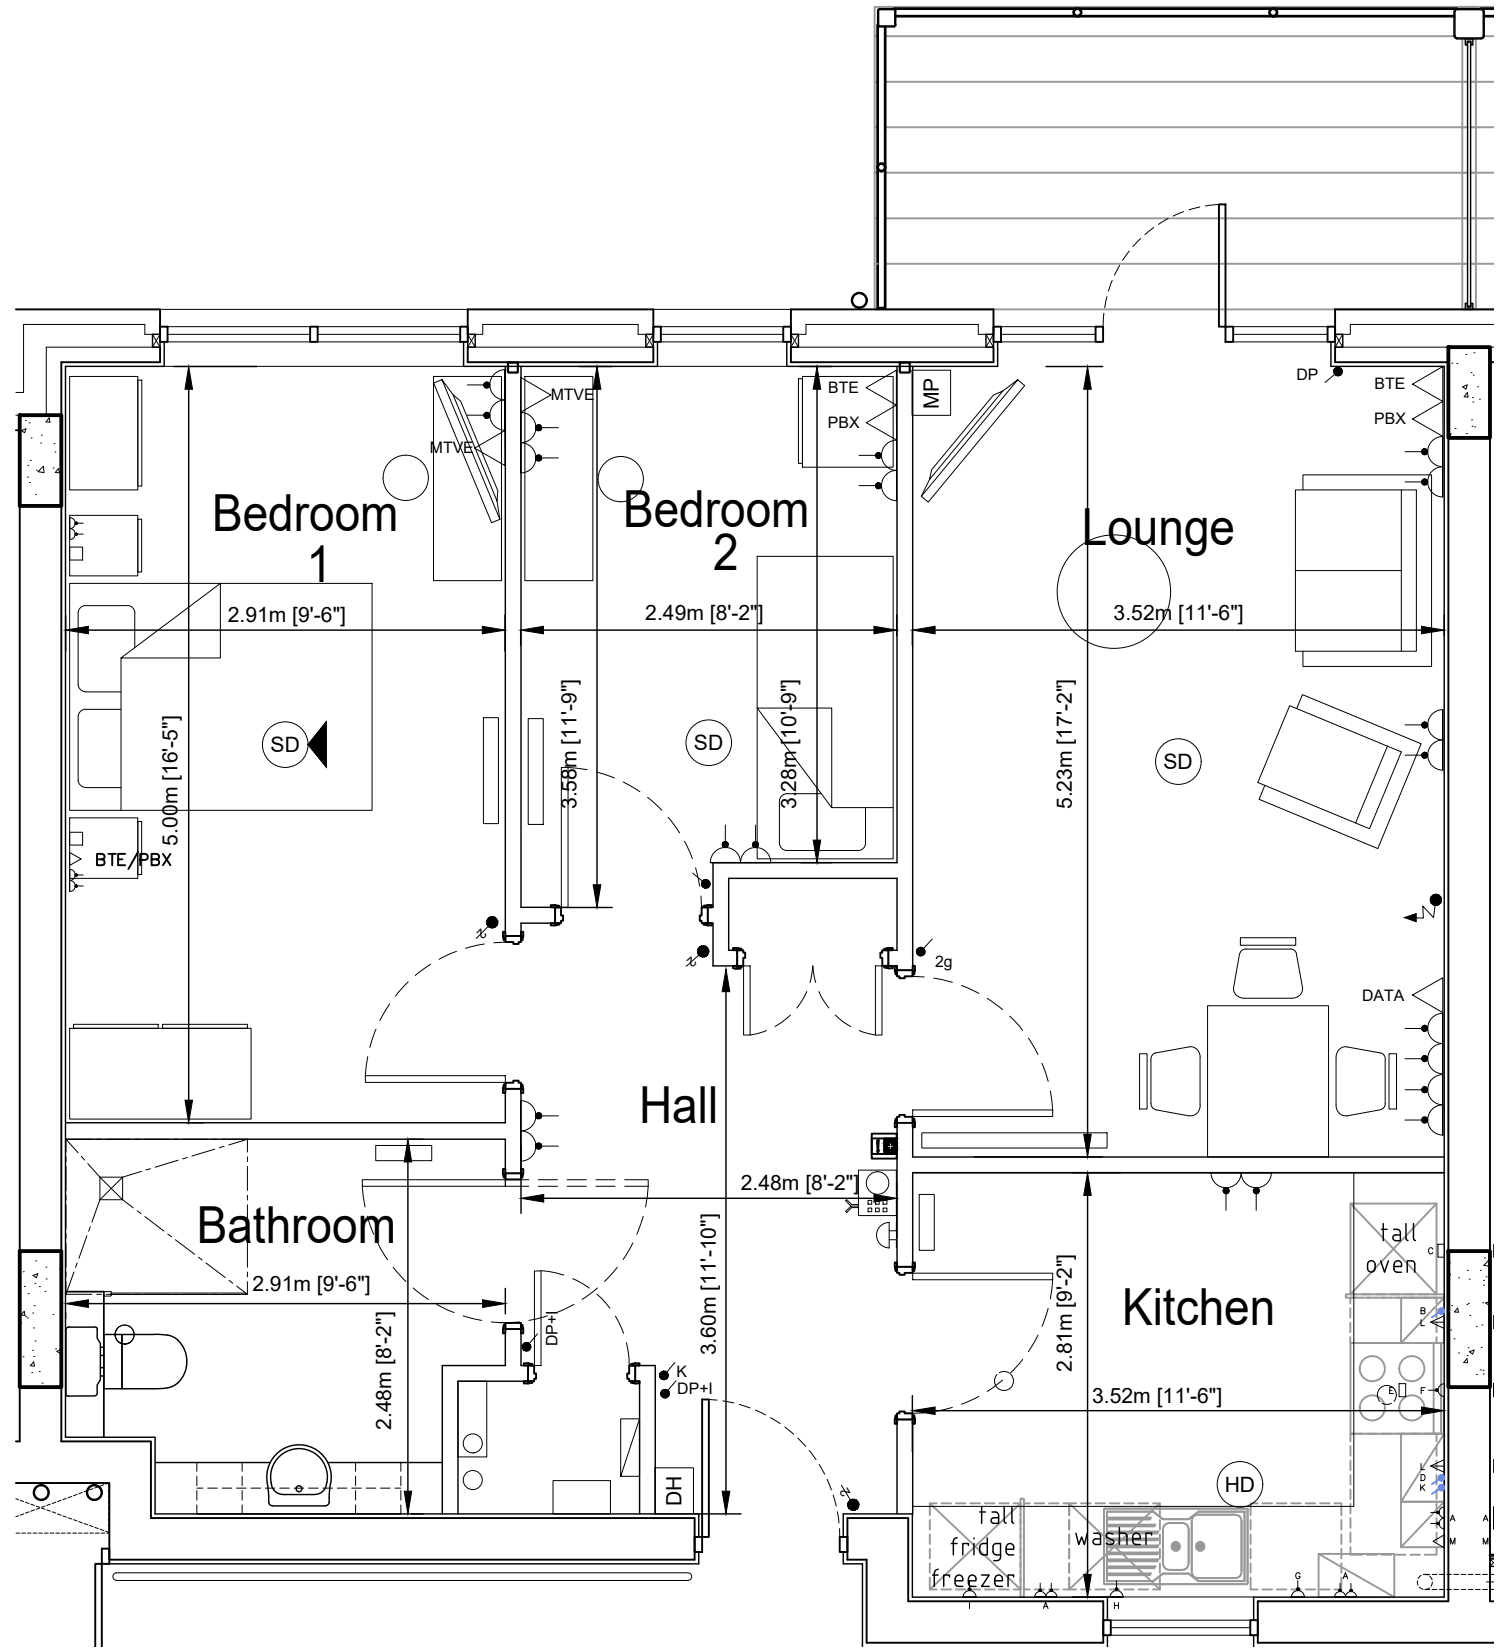


Apartment 118



 
Copyright of this drawing is vested in the Architect and it must not be copied or reproduced without consent. Every effort has been made to ensure these details are correct but this does not constitute a legal document.

DO NOT SCALE OFF THIS DRAWING. IF IN DOUBT ASK.

THE INFORMATION IN THIS LEAFLET DOES NOT IN ANY WAY FORM PART OF A CONTRACT OR WARRANTY.

THE PARTICULARS ARE SENT OUT AS A GENERAL OUTLINE FOR GUIDANCE ONLY.

KEY TO DIMENSIONS



Dimensions subject to construction tolerances and are for guidance only.

LEGEND

- | | | | |
|--|---|--|--|
| | 1 WAY LIGHT SWITCH (DP=DOUBLE POLE) (WIDE ROCKER TYPE) | | ENERGY SAVING CEILING MOUNTED LIGHT ASD AC/WL100 |
| | 2 WAY LIGHT SWITCH (WIDE ROCKER TYPE) | | CEILING ROSE WITH LOW ENERGY LIGHT CRABTREE 5255/S |
| | MVHR ISOLATING SWITCH | | CIRCULAR STANDARD CEILING LIGHT THORN NOVALINE 3x26W TC-DEL |
| | EMERGENCY LIGHTING KEY SWITCH TO TEST ALL EMERGENCY LIGHTS | | CIRCULAR EMERGENCY CEILING LIGHT THORN NOVALINE 3x26W TC-DEL |
| | INTERMEDIATE SWITCH | | LOW ENERGY EXTERNAL BULKHEAD - ASD CLARITY LANDSCAPE IP65 EYELID, COLOUR DEPENDS ON EXTERNAL WALL FINISH |
| | 'I' DENOTES LED INDICATOR | | WALL LIGHT AS FRANKLITE WB243EL/8SS |
| | TELEPHONE OUTLET | | TWIN SWITCHED SOCKET (NEON INDICATOR) |
| | BT MASTER TELEPHONE OUTLET | | SWITCHED SPUR C/W NEON INDICATOR |
| | BT EXTENSION TELEPHONE OUTLET WIRED TO BT MASTER OUTLET. | | DENOTES DOORBELL |
| | MATV SYSTEM - MASTER | | DENOTES FAN UNIT |
| | MATV - TV OUTLET EXTENSION | | DENOTES GATEWAY BOX |
| | RJ45 OUTLET | | DENOTES TV AMPLIFIER |
| | HEAT DETECTOR | | FIRE DOOR CLOSER CONNECTION POINT (these are wired from external fire alarm system) |
| | OPTICAL SMOKE DETECTOR | | WALL MOUNTED REACH PLUS UNIT C/W PULL CORD & HUSH BUTTON |
| | OPTICAL SMOKE DETECTOR (SOUNDER BASE) | | SHAVER POINT DUAL VOLTAGE |
| | MULTIFUNCTION DETECTOR (SOUNDER BASE) | | VENTILATION AIR VALVE |
| | EMERGENCY PULL CORD 150mm FROM WALL EXCEPT BATHROOM | | CONSUMER UNIT (low level) - 1200mm |
| | DOOR BELL SOUNDER | | 3 GANG GRID SWITCH c/w FOLLOWING SWITCHES
* WASHING MACHINE/DRYER
* FRIDGE FREEZER
* DISHWASHER |
| | DOOR BELL PUSH | | |
| | SELF CONTAINED SW NON MAINTAINED EMERGENCY BULKHEAD IP65 | | |
| | MEDIA PLATE (CRABTREE 4318 WHITE OR CHROME) CONTAINING FOLLOWING:
2-TWIN 13A SOCKETS
1-BT OUTLET
1-PBX OUTLET
4-1 EACH SAT1, SAT2, TV, FM/DAB OUTLETS
1-SATELLITE RETURN
2-BLANKS | | |
| | * WHERE BTE AND PBX OUTLETS ARE INSTALLED TOGETHER, THEY SHALL BE MOUNTED AS A TWIN OUTLET PLATE FIXED ONTO A SINGLE SOCKET BOX. | | |
| | MAIN WATER BOND | | |
- KITCHEN KEY
- | | |
|----|--|
| A | TWIN 13A SSO ABOVE WORKTOP |
| B | OVEN SWITCH ABOVE WORKTOP |
| C | OVEN OUTLET |
| D | HOB SWITCH ABOVE WORKTOP |
| E | HOB OUTLET |
| F | HIGH LEVEL SOCKET FOR COOKER HOOD |
| G | LOW LEVEL SOCKET FOR DISHWASHER |
| H | LOW LEVEL SOCKET FOR WASHER/DRYER |
| I | SOCKET FOR FRIDGE/FREEZER |
| J | 3G GRID SWITCH CONTROLLING ITEMS F,H & I - STANDARD APTS
4G GRID SWITCH CONTROLLING ITEMS F, G, H & I - ENHANCED APTS |
| K | FAN BOOST SWITCH ABOVE WORKTOP |
| L | CONNECTION POINT FOR UNDER CUPBOARD LIGHTING |
| M | PBX RJ45 OUTLET ABOVE WORKTOP |
| UC | UNDER CUPBOARD LIGHT SWITCH |
| ML | MAIN LIGHT SWITCH |

Scale. 1:50 @ A3 Date. Feb 2017 Drawn. AD

Client. ExtraCare Charitable Trust

Marketing Drawing

Job title. High Wycombe Retirement Village

1st Floor

2 Bed Apartment - Enhanced

B6437 (M)118 - Apartment 118

Unit 118 Area = 70 m²

