


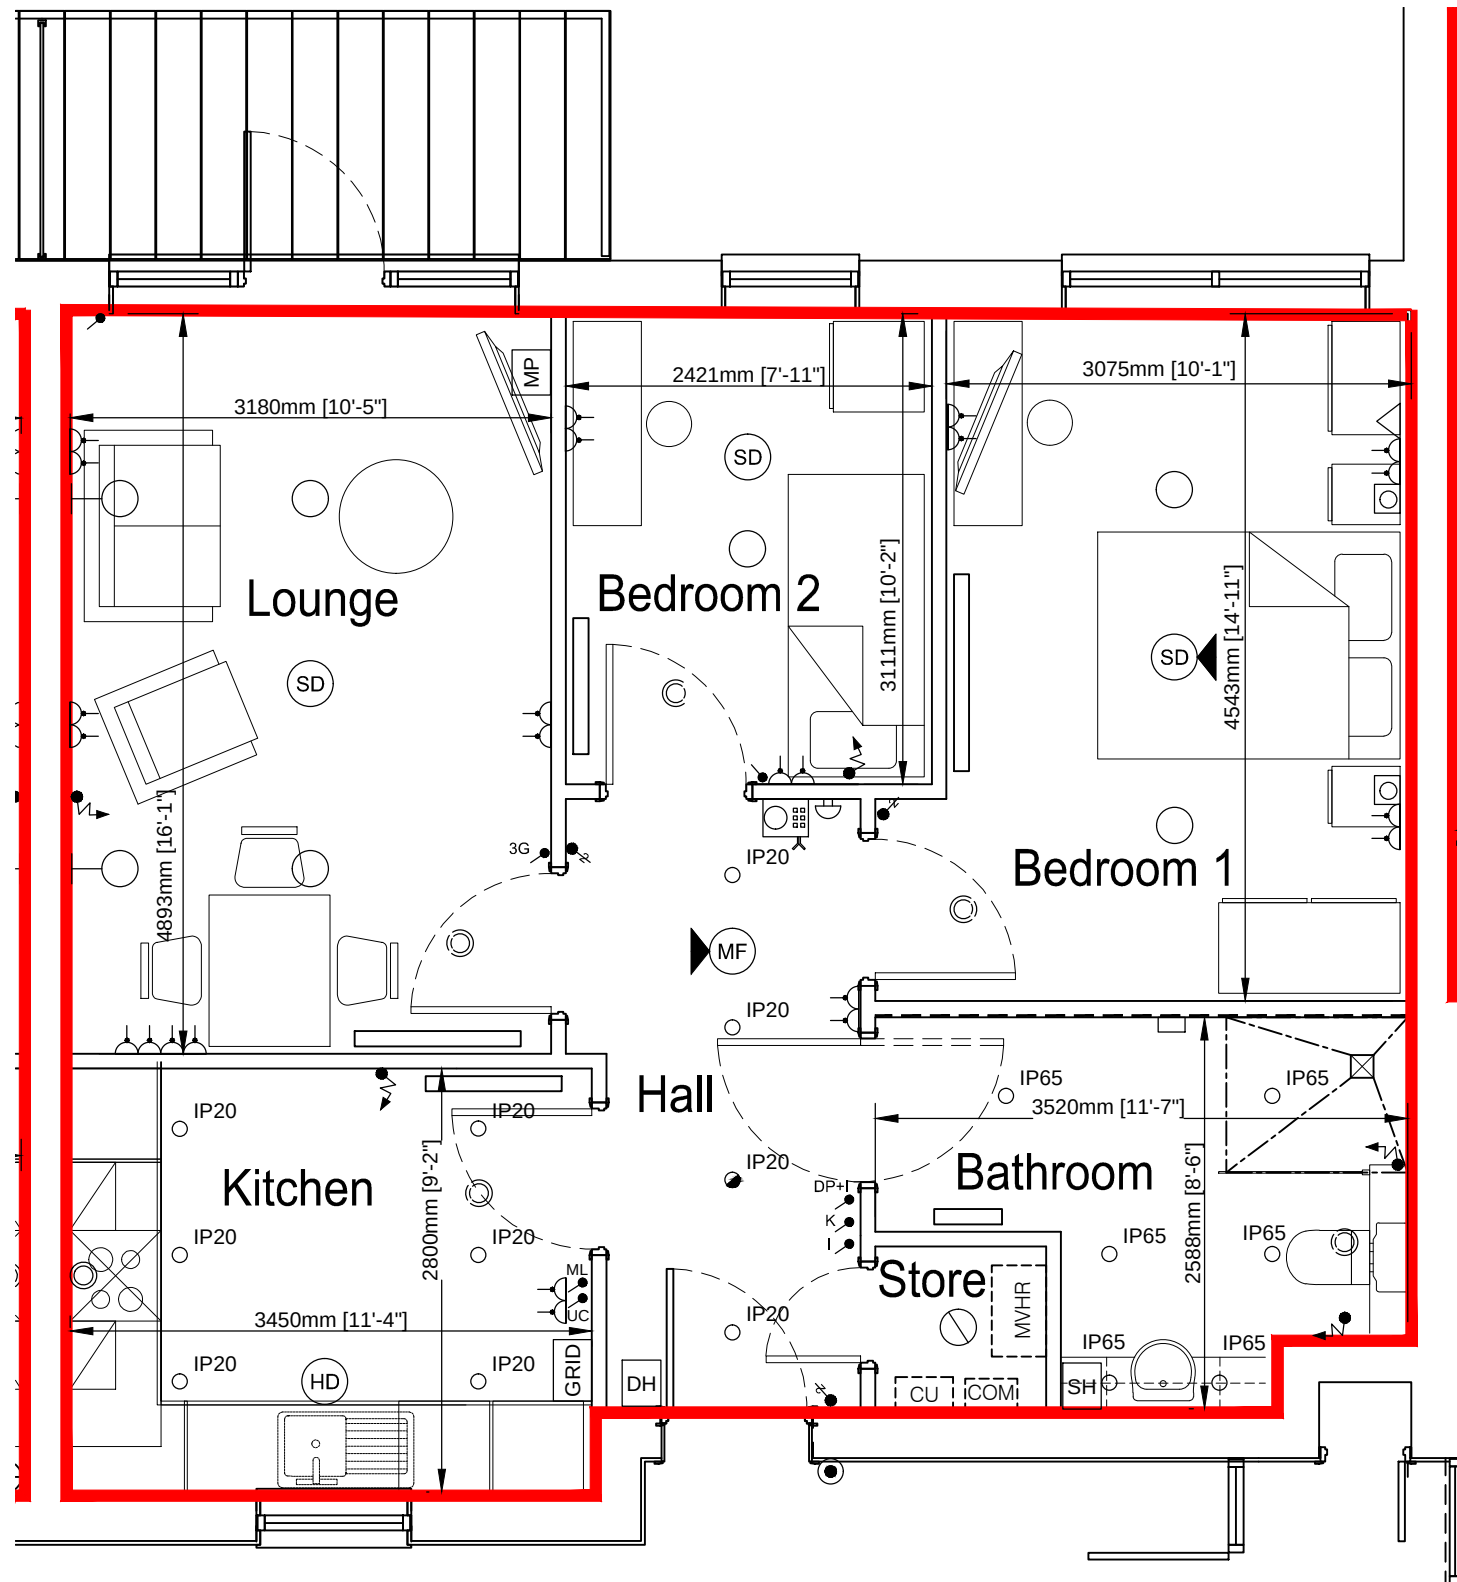

	1 WAY LIGHT SWITCH (DP=DOUBLE POLE)		TWIN SWITCHED SOCKET (NEON INDICATOR)
	2 WAY LIGHT SWITCH (WIDE ROCKER TYPE)		SWITCHED SOCKET (NEON INDICATOR)
	FAN ISOLATING SWITCH		FIRE DOOR CLOSER CONNECTION POINT (these are wired from external fire alarm system)
	EMERGENCY LIGHTING KEY SWITCH		TV MASTER UNIT
	INTERMEDIATE SWITCH		DISPERSED ALARM UNIT WITH PULL CORD
	TELEPHONE OUTLET		SHAVER POINT
	BT MASTER TELEPHONE OUTLET		CONSUMER UNIT (low level) – 1200mm
	BT EXTENSION TELEPHONE OUTLET WIRED TO BT MASTER OUTLET.		RADIATOR
	MATV SYSTEM – MASTER		3 GANG GRID SWITCH c/w FOLLOWING SWITCHES * WASHING MACHINE/DRYER * FRIDGE FREEZER * DISHWASHER NOTE: ENHANCED FLATS HAVE A 4 GANG SWITCH WHICH INCLUDES A SWITCH FOR THE COOKER HOOD
	MATV – TV OUTLET EXTENSION		SWITCHED FCU
	SATV SYSTEM – MASTER		ENERGY SAVING 18W TC-TEL LAMP, HF, RECESSED DOWNLIGHTER WITH WHITE BEZEL. IP44, CLEAR GLASS ATTACHMENT, 125 Ø MM MAX. COMPLETE. FIRE RATED LUMINAIRES SHALL BE FITTED THROUGH FIRE RATED CEILINGS, AS AURORA LPF650+LPF683. ALL TOP FLOOR APARTMENT RECESSED LUMINAIRES SHALL BE ENCLOSED WITHIN AN INSULATION SUPPORT BOX TO ENSURE FREE AIR SURROUNDS THE LUMINAIRE.
	HEAT DETECTOR		W DENOTES FROSTED GLASS ATTACHMENT
	OPTICAL SMOKE DETECTOR		ENERGY SAVING 18W TC-TEL LAMP, HF, RECESSED DOWNLIGHTER WITH WHITE BEZEL. IP44, CLEAR GLASS ATTACHMENT, 125 Ø MM MAX. COMPLETE WITH INVERTER AND 3 HOUR EMERGENCY BATTERY PACK. FIRE RATED LUMINAIRES SHALL BE FITTED THROUGH FIRE RATED CEILINGS, AS AURORA LPF650/EM+LPF683. ALL TOP FLOOR APARTMENT RECESSED LUMINAIRES SHALL BE ENCLOSED WITHIN AN INSULATION SUPPORT BOX TO ENSURE FREE AIR SURROUNDS THE LUMINAIRE.
	OPTICAL SMOKE DETECTOR (SOUNDER BASE)		MEDIA PLATE CONTAINING FOLLOWING: 3-TWIN 13A SOCKETS 1-BT OUTLET 1-PBX OUTLET AND ALL OUTLETS TO RECEIVE DTV, FM, DAB, SKY+, FREESAT & SKY RETURN * WHERE BTE AND PBX OUTLETS ARE INSTALLED TOGETHER, THEY SHALL BE MOUNTED AS A TWIN OUTLET PLATE FIXED ONTO A SINGLE SOCKET BOX.
	Co CARBON MONOXIDE DETECTOR (SOUNDER BASE)		
	EMERGENCY PULL CORD		
	UNDER CUPBOARD LIGHT		
	DOOR BELL SOUNDER		
	DOOR BELL PUSH		
	EXTRACTOR FAN		
	ENERGY SAVING CEILING MOUNTED LIGHT		
	CEILING ROSE WITH LOW ENERGY LIGHT		
	CIRCULAR LIGHT		
	LED NON MAINTAINED EMERGENCY LIGHT, FIRE RATED AND WITH INSULATION SUPPORT BOX ON TOP FLOOR APARTMENTS.		

THE PARTICULARS ARE SENT OUT AS A GENERAL OUTLINE FOR GUIDANCE ONLY.

Drawing No. B5922 - Lickey Road - Apartment... 108
Ground Floor... Block H
Apartment Type G
Unit 108 Area = 66.20m²