



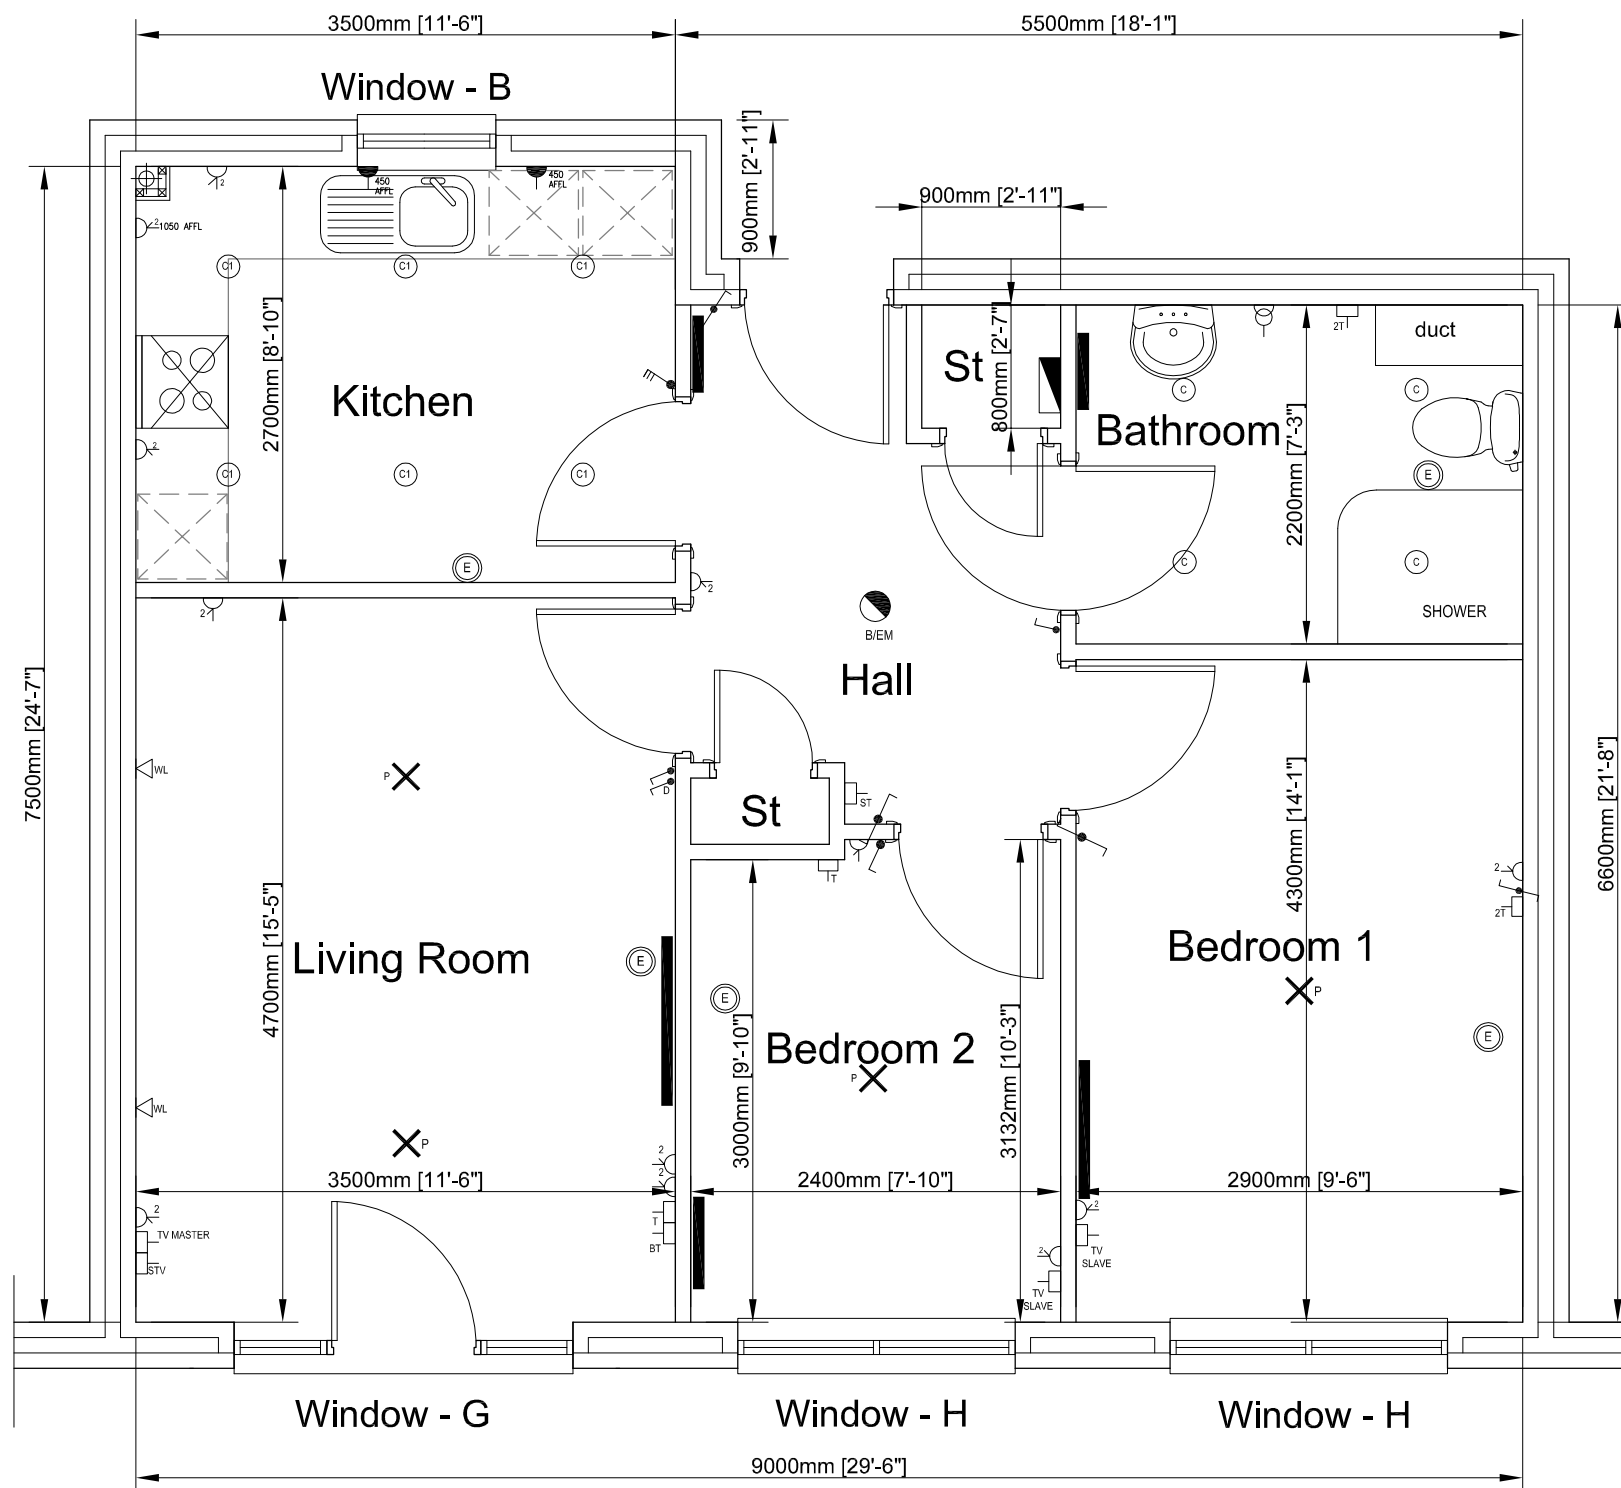

Copyright of this drawing is vested in the Architect and it must not be copied or reproduced without consent. Figured dimensions only are to be taken from this drawing. All contractors must visit the site and be responsible for taking and checking all dimensions relative to their work.
DO NOT SCALE OFF THIS DRAWING. IF IN DOUBT ASK

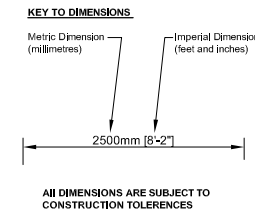

Plans produced from the following drawings:

PRP Architects

PRP - A3324/2.3/501 rev B
PRP - A3324/4.1/100 rev D
PRP - A3324/4.1/110 rev D
PRP - A3324/4.1/120 rev D
PRP - A3324/4.1/130 rev D

DODD GROUP

111652-E092 AI (as installed drawing)

LEGEND

- LIGHTING CONTROL SWITCH.
- 2 WAY LIGHTING CONTROL SWITCH.
- LIGHTING CONTROL SWITCH (WALL LIGHTS).
- MASTER TELEPHONE POINT.
- MASTER SAYPHONE UNIT.
- TV POINT.
- SATELLITE TV POINT.
- TELEPHONE POINT.
- DUAL TELEPHONE POINT.
- SINGLE SOCKET C/W NEON INDICATOR.
- DOUBLE SOCKET C/W NEON INDICATOR.
- LOW LEVEL SOCKET FOR DISHWASHER/ WASHING MACHINE/FRIDGE/FREEZER.
- WARDEN CALL ASSISTANCE PULL CORD.
- B/EM CEILING MOUNTED SUSPENDED LUMINAIRE
- C CEILING MOUNTED SPOT LIGHTS
- C1 CEILING MOUNTED SPOT LIGHTS
- P X CEILING ROSE WITH BC PENDANT
- CONSUMER UNIT
- RADIATOR
- WL WALL LIGHT
- SHAVER POINT

Scale. 1:50 @A3 Date. Mar 06 Drawn. Pjh

Client. The ExtraCare Charitable Trust

Marketing Drawings

Job title. Milton Keynes

ExtraCare Village

Drawing No. B4261 - 122

First Floor Layout

Apartment Type C (Enhanced)

Unit 122 Area = 62.5m²

Floor Plans are for
indicative purposes only;
layouts and dimensions
may differ