
 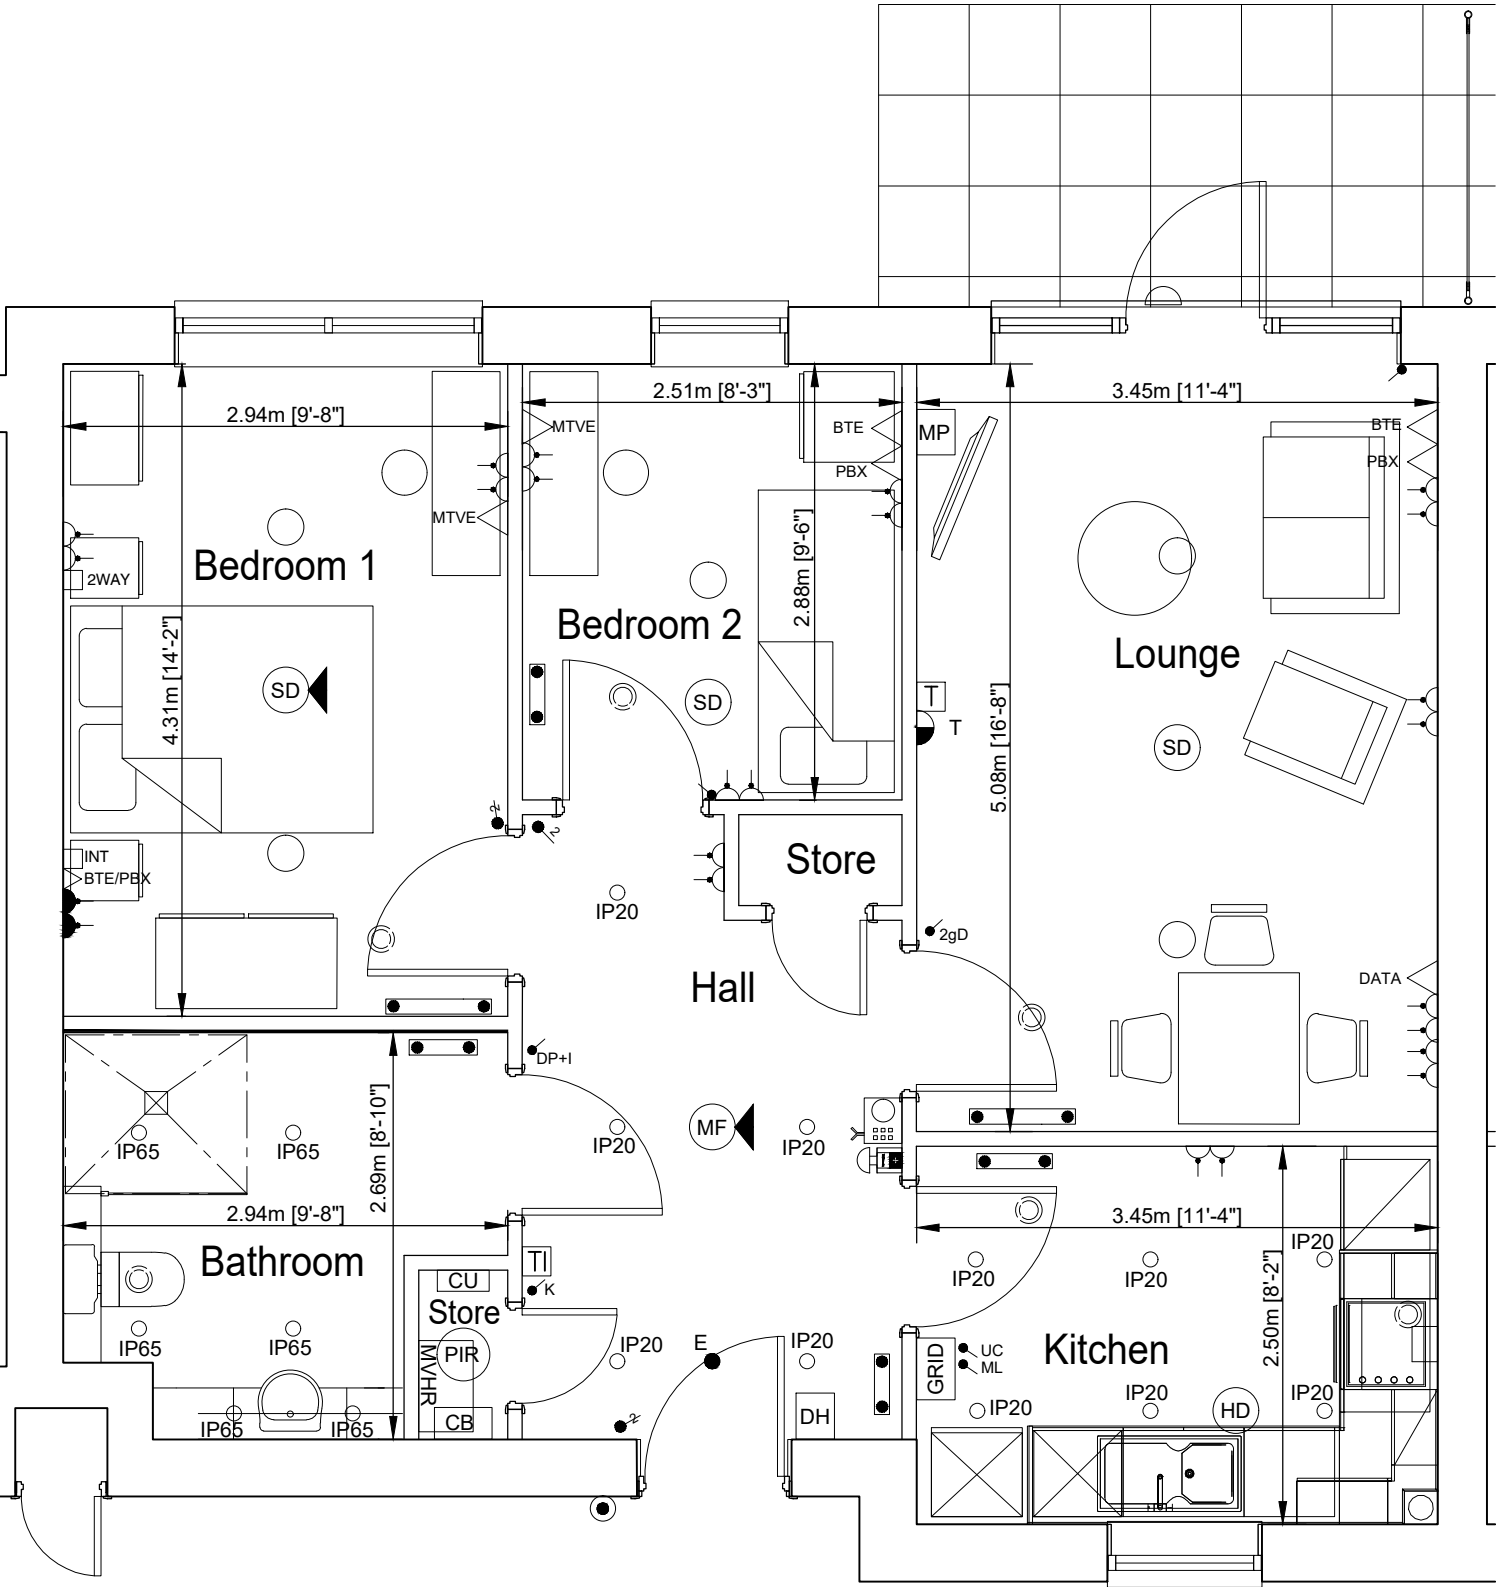




LEGEND

- | | | | |
|--|---|--|--|
| | 10W LED CEILING MOUNTED LIGHT | | 1 WAY LIGHT SWITCH (DP=DOUBLE POLE) (WIDE ROCKER TYPE) |
| | 10W LED CEILING MOUNTED LIGHT C/W WITH PIR | | 2 WAY LIGHT SWITCH (WIDE ROCKER TYPE) |
| | CEILING ROSE WITH LOW ENERGY LIGHT CRABTREE 5255/S | | MVHR ISOLATING SWITCH |
| | LOW ENERGY EXTERNAL BULKHEAD - ASD CLARITY LANDSCAPE IP65 EYELID, COLOUR DEPENDS ON EXTERNAL WALL FINISH | | EMERGENCY LIGHTING KEY SWITCH TO TEST ALL EMERGENCY LIGHTS |
| | BACK BOX & COVER PLATE FOR FUTURE WALL LIGHTS (ENH APTS ONLY) | | INTERMEDIATE SWITCH |
| | TWIN SWITCHED SOCKET (NEON INDICATOR) WITH OUTBOARD ROCKERS | | 'N' DENOTES NEON INDICATOR |
| | SWITCHED FUSED CONNECTION UNIT C/W NEON INDICATOR | | 'I' DENOTES LED INDICATOR |
| | DENOTES DOORBELL | | 'D' DENOTES DIMMER |
| | DENOTES FAN UNIT | | BED HEAD LIGHT SWITCH |
| | DENOTES GATEWAY BOX | | TELEPHONE OUTLET |
| | DENOTES TV AMPLIFIER | | BT MASTER TELEPHONE OUTLET |
| | DENOTES THERMOSTAT | | BT EXTENSION TELEPHONE OUTLET WIRED TO BT MASTER OUTLET. |
| | FIRE DOOR CLOSER CONNECTION POINT (these are wired from external fire alarm system) | | MATV SYSTEM - MASTER |
| | WALL MOUNTED REACH PLUS UNIT C/W PULL CORD & HUSH BUTTON (120x187mm) | | MATV - TV OUTLET EXTENSION |
| | CONSUMER UNIT (low level) - 1200mm | | RJ45 OUTLET |
| | 4 GANG GRID SWITCH c/w FOLLOWING SWITCHES: WASHING MACHINE/DRYER, FRIDGE FREEZER, DISHWASHER, EXTRACT HOOD | | BT FIBRE OUTLET |
| | RADIATOR | | HEAT DETECTOR |
| | INFONET UNIT (165x165mm) | | OPTICAL SMOKE DETECTOR (SOUNDER BASE) |
| | THERMOSTAT | | OPTICAL SMOKE DETECTOR (SOUNDER BASE) |
| | THERMOSTAT FOR MVHR SUMMER/WINTER CONTROL | | MULTIFUNCTION DETECTOR (SOUNDER BASE) |
| | JCC RECESSED GU10 DOWNLIGHT IP65 RATED C/W 7W 500 LUMEN G10 LAMP MINIMUM 30,000 HOURS LAMP LIFE, COLOUR 840. BRUSHED CHROME BEZEL. REF JC2107CH. | | EMERGENCY PULL CORD 150mm FROM WALL EXCEPT BATHROOM |
| | JCC RECESSED GU10 DOWNLIGHT IP20 RATED C/W 7W 500 LUMEN G10 LAMP MINIMUM 30,000 HOURS LAMP LIFE, COLOUR 840. BRUSHED CHROME BEZEL. REF JC2033CH. | | DOOR BELL SOUNDER (200X120mm) |
| | MEDIA PLATE (CRABTREE 4318 WHITE OR CHROME) CONTAINING FOLLOWING: 2-TWIN 13A SOCKETS, 1-RJ45 OUTLET FOR BT, 1-RJ45 OUTLET FOR SMART TV, 4-1 EACH SAT1, SAT2, TV, FM/DAB OUTLETS, 1-SATELLITE RETURN, 1-BLANK FOR FUTURE SKY QUAD OUTLET | | DOOR BELL PUSH @ 1000AFFL |
| | WHERE BTE AND PBX OUTLETS ARE INSTALLED TOGETHER, THEY SHALL BE MOUNTED AS A TWIN OUTLET PLATE FIXED ONTO A SINGLE SOCKET BOX. | | |
| | MAIN WATER BOND | | |
| | EXTRACT AIR VALVE | | |
| | NON-MAINTAINED EMERGENCY LUMINAIRE | | |
| | TWIN SWITCHED SOCKET (NEON INDICATOR) WITH OUTBOARD ROCKERS C/W USB SOCKET (47mm BACKBOX REQUIRED) LOCATED IN ALL APT BEDROOMS AND TYPE L KITCHEN | | |

- KITCHEN ACCESSORIES**
- 3 x TWIN SOCKETS ABOVE WORKTOP
 - 1 x HOB SUPPLY & OUTLET
 - 1 x OVEN SUPPLY & OUTLET
 - 3 x UNDER CUPBOARD LIGHTING POINTS (DEPENDANT ON LAYOUTS) STD & ENH
 - 1 x MULTIGANG SWITCH CONTROLLING:
 - 1 x EXTRACT HOOD
 - 1 x FRIDGE FREEZER
 - 1 x WASHER DRYER
 - 1 x DISHWASHER - FUTURE - ENH ONLY
 - 1 x FAN BOOST SWITCH

Copyright of this drawing is vested in the Architect and it must not be copied or reproduced without consent. Every effort has been made to ensure these details are correct but this does not constitute a legal document.

DO NOT SCALE OFF THIS DRAWING. IF IN DOUBT ASK.

THE INFORMATION IN THIS LEAFLET DOES NOT IN ANY WAY FORM PART OF A CONTRACT OR WARRANTY.

THE PARTICULARS ARE SENT OUT AS A GENERAL OUTLINE FOR GUIDANCE ONLY.

KEY TO DIMENSIONS

Metric Dimension (meters) Imperial Dimension (feet and inches)

1.56m [5'-2"]

Dimensions subject to construction tolerances and are for guidance only.

Scale. 1:50 @ A3 Date. Oct 2017 Drawn. EB

Client. The ExtraCare Charitable Trust

Marketing Drawings

Job title. ExtraCare Retirement Village

Coldharbour Lane, Bristol

B5463-Sales-Level 1

Ground Floor

Apartment Type B (Standard)

Unit 108 Area = 66.8m²

Apartment 108 Type B - 2 Bedroom

